


NOTES:
 ① DISCONNECT MOTOR. REMOVE CONDUCTORS AND EXPOSED CONDUITS FROM MOTOR TO MOTOR STARTER.

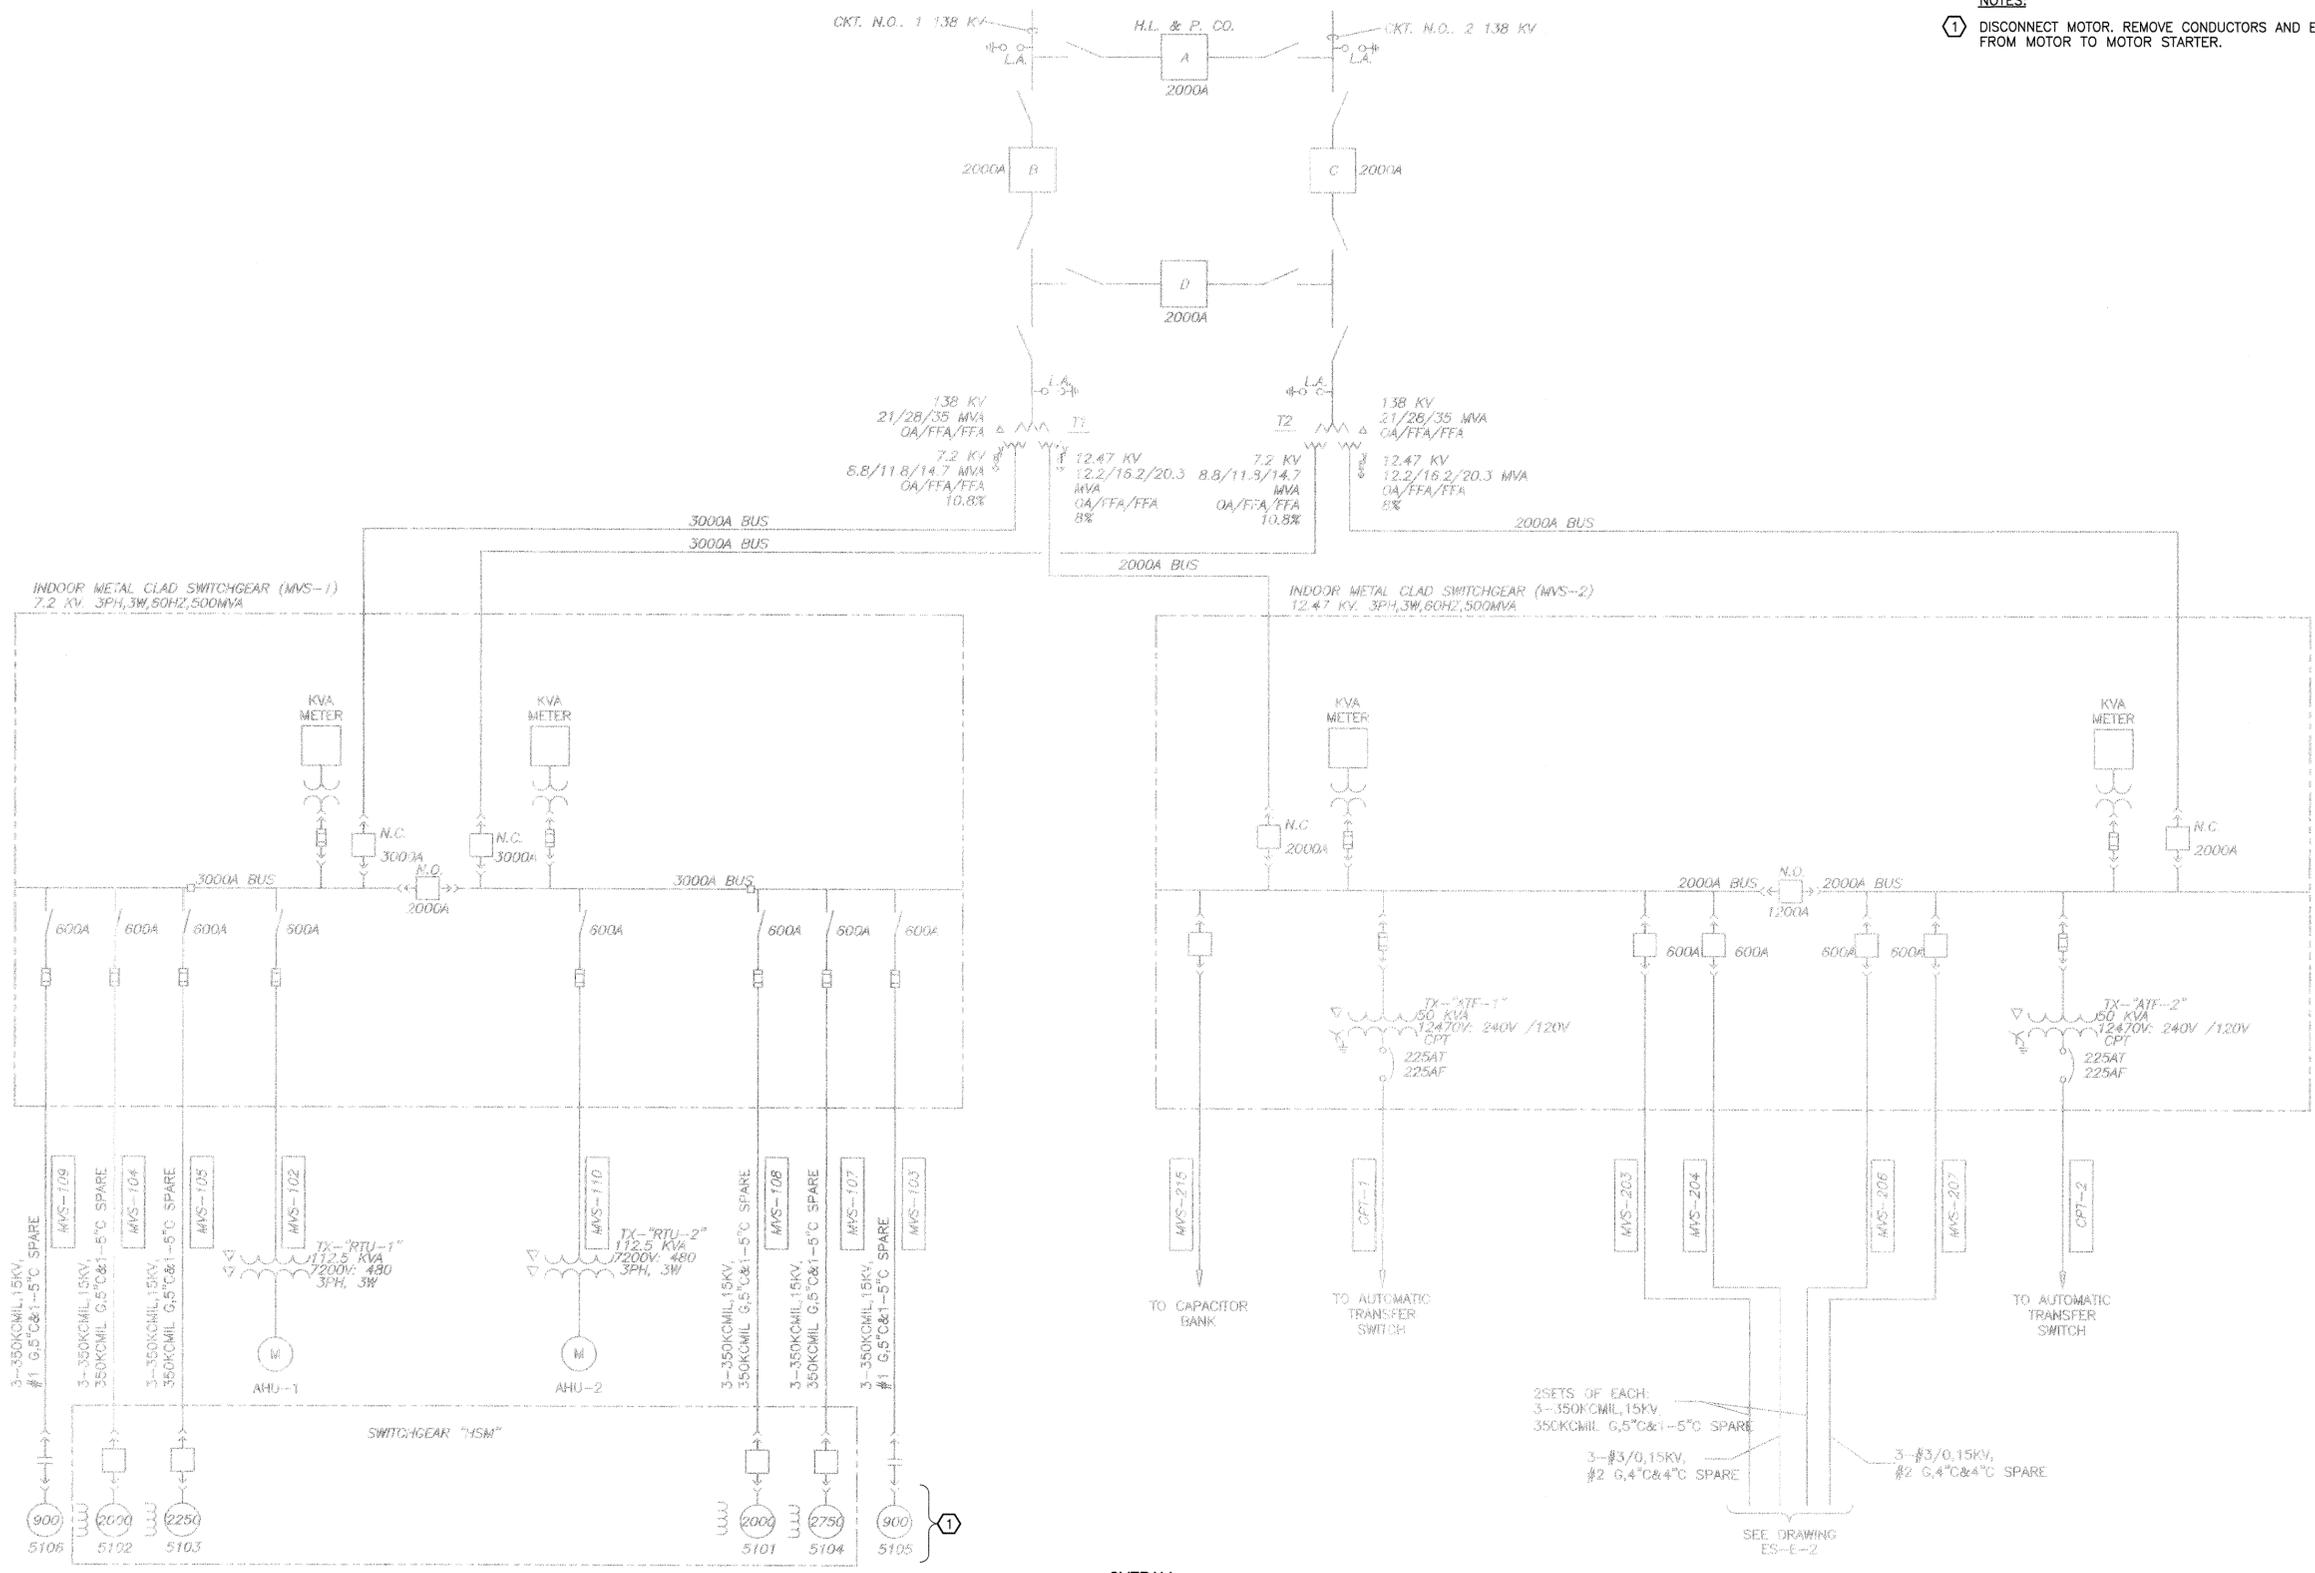

OVERALL
 ONE-LINE DIAGRAM
 NTS

LOCATED AT HIGH SERVICE PUMP STATION

No.	Date	Revisions	App.

PRIVATE UTILITY LINES SHOWN

CENTER POINT ENERGY/GAS FACILITIES

SBC CO. VALID FOR ONE YEAR
 APPROVED ONLY FOR UNDERGROUND CONDUIT FACILITIES
 UNLESS NOTED.


CENTER POINT ENERGY/ELECTRIC FACILITIES
 APPROVED ONLY FOR CROSSING UNDERGROUND DUCTLINES
 UNLESS NOTED. VALID AT TIME OF REVIEW ONLY.

CABLE COMPANY

KGI Kalluri Group, Inc.
 Consulting Engineers & Project Managers
 10497 Town & Country Way, Suite 220
 Houston, Texas 77024
 Phone: (713)-365-9288

APPROVED: MHW DATE: 09-15-06
 DESIGNED BY: MHW DRAWN BY: KCW

CDM Camp Dresser & McKee Inc.
 consulting • engineering • construction • operations
 3050 POST OAK BLVD, SUITE 300, HOUSTON, TEXAS 77056
 (713) 423-7300 FAX (713) 840-0173

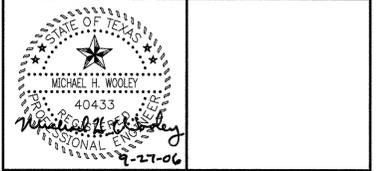

SURVEYED BY: RBI FB NO. P-5142

CITY OF HOUSTON
 DEPARTMENT OF PUBLIC WORKS AND ENGINEERING

**SOUTHEAST WATER PURIFICATION PLANT
 PHASE I - 80 MGD EXPANSION**

EXISTING
 OVERALL ONE-LINE DIAGRAM
 SHEET 1 OF 2
 ELECTRICAL

WARNING 0 1 IF THIS BAR DOES NOT MEASURE 1" THEN DRAWING IS NOT TO SCALE	FILE NO. WA10484-11	
	GFS NO. S-0012-20-3	
DRAWING SCALE AS SHOWN		
CITY OF HOUSTON PM AVATAR MANN, P.E.		
SHEET NO. 144 OF 953		