

ENLARGED DEMOLITION ROOF PLAN

SCALE: 1/16" = 1'-0"

1

SOIL/PLUMBING VENT	FLANGE MOUNTED EQUIPMENT	HOT STACK	CURB MOUNTED VENT	A/C UNIT	CURB MOUNTED EQUIPMENT	MISCELLANEOUS EQUIPMENT ON PP	PRIMARY ROOF DRAIN	OVERFLOW ROOF DRAIN	PRIMARY AND OVERFLOW ROOF DRAIN	DOWNSPOUT/SPLASHBLOCK	DOWNSPOUT	EXISTING ROOF DRAIN	EXPANSION JOINT	METAL EDGE W/GUTTER	METAL EDGE	RISE WALL	RAISED METAL EDGE	RISE WALL W/EXPANSION JOINT
PITCH PAN	PROCESS VENT STACK	VENT STACK	FLANGE MOUNTED VENT	PLENUM A/C ON PITCH PANS	MISCELLANEOUS EQUIPMENT	ROOF HATCH	SCUPPER	OVERFLOW SCUPPER	EDGE SCUPPER	DOWNSPOUT/ COLLECTOR HEAD	THROUGH WALL SCUPPER	EXISTING OVERFLOW ROOF DRAIN	PARAPET	EXPANSION JOINT AT PARAPET	SLOPE DIRECTION	EXISTING PARAPET	METAL WALL PANELS	SKYLIGHT

ROOF LEGEND

PRE-FINISHED STANDING SEAM METAL ROOF AS SPECIFIED
ROOF SYSTEM AS SPECIFIED
NOT IN CONTRACT

ISSUE LOG		
NO.	DATE	DESCRIPTION

CITY OF HOUSTON
GENERAL SERVICES
DEPARTMENT



900 BAGBY, HOUSTON, TX 77002

PROJECT NAME :
2903 JENSEN DRIVE
ROOF REPAIR/ COATING AND
PARKING LOT REPAIR
AND RESURFACING
VICTORY PREPARATORY ACADEMY
(PROJ#-P-000011)

APPROVALS :

PROJECT MANAGER	DATE
CHIEF ENGINEER	DATE
ASSISTANT DIRECTOR	DATE

CONSULTANT:


ARCHI*TECHNICS/3
5555 West Loop S, Suite 400
Bellaire, Texas 77401
713/868-0088 713/468-2613

INTEGRATED MANAGEMENT SERVICES, P.A. INC.
ENGINEERS PLANNERS PROJECT MANAGERS
723 MAIN STREET, SUITE 250
HOUSTON, TEXAS 77002
OFFICE #713-739-7744
FAX#713-739-7746

PROJECT NO : P-000011
ACAD DWG. FILE :
DRAWN BY : JA
CHECKED BY : MRJ
COPY RIGHT :

SHEET TITLE :
ENLARGED DEMOLITION ROOF PLAN

D-1.1
SHEET NO. 3 OF 8 SHEETS
CITY DWG NO :

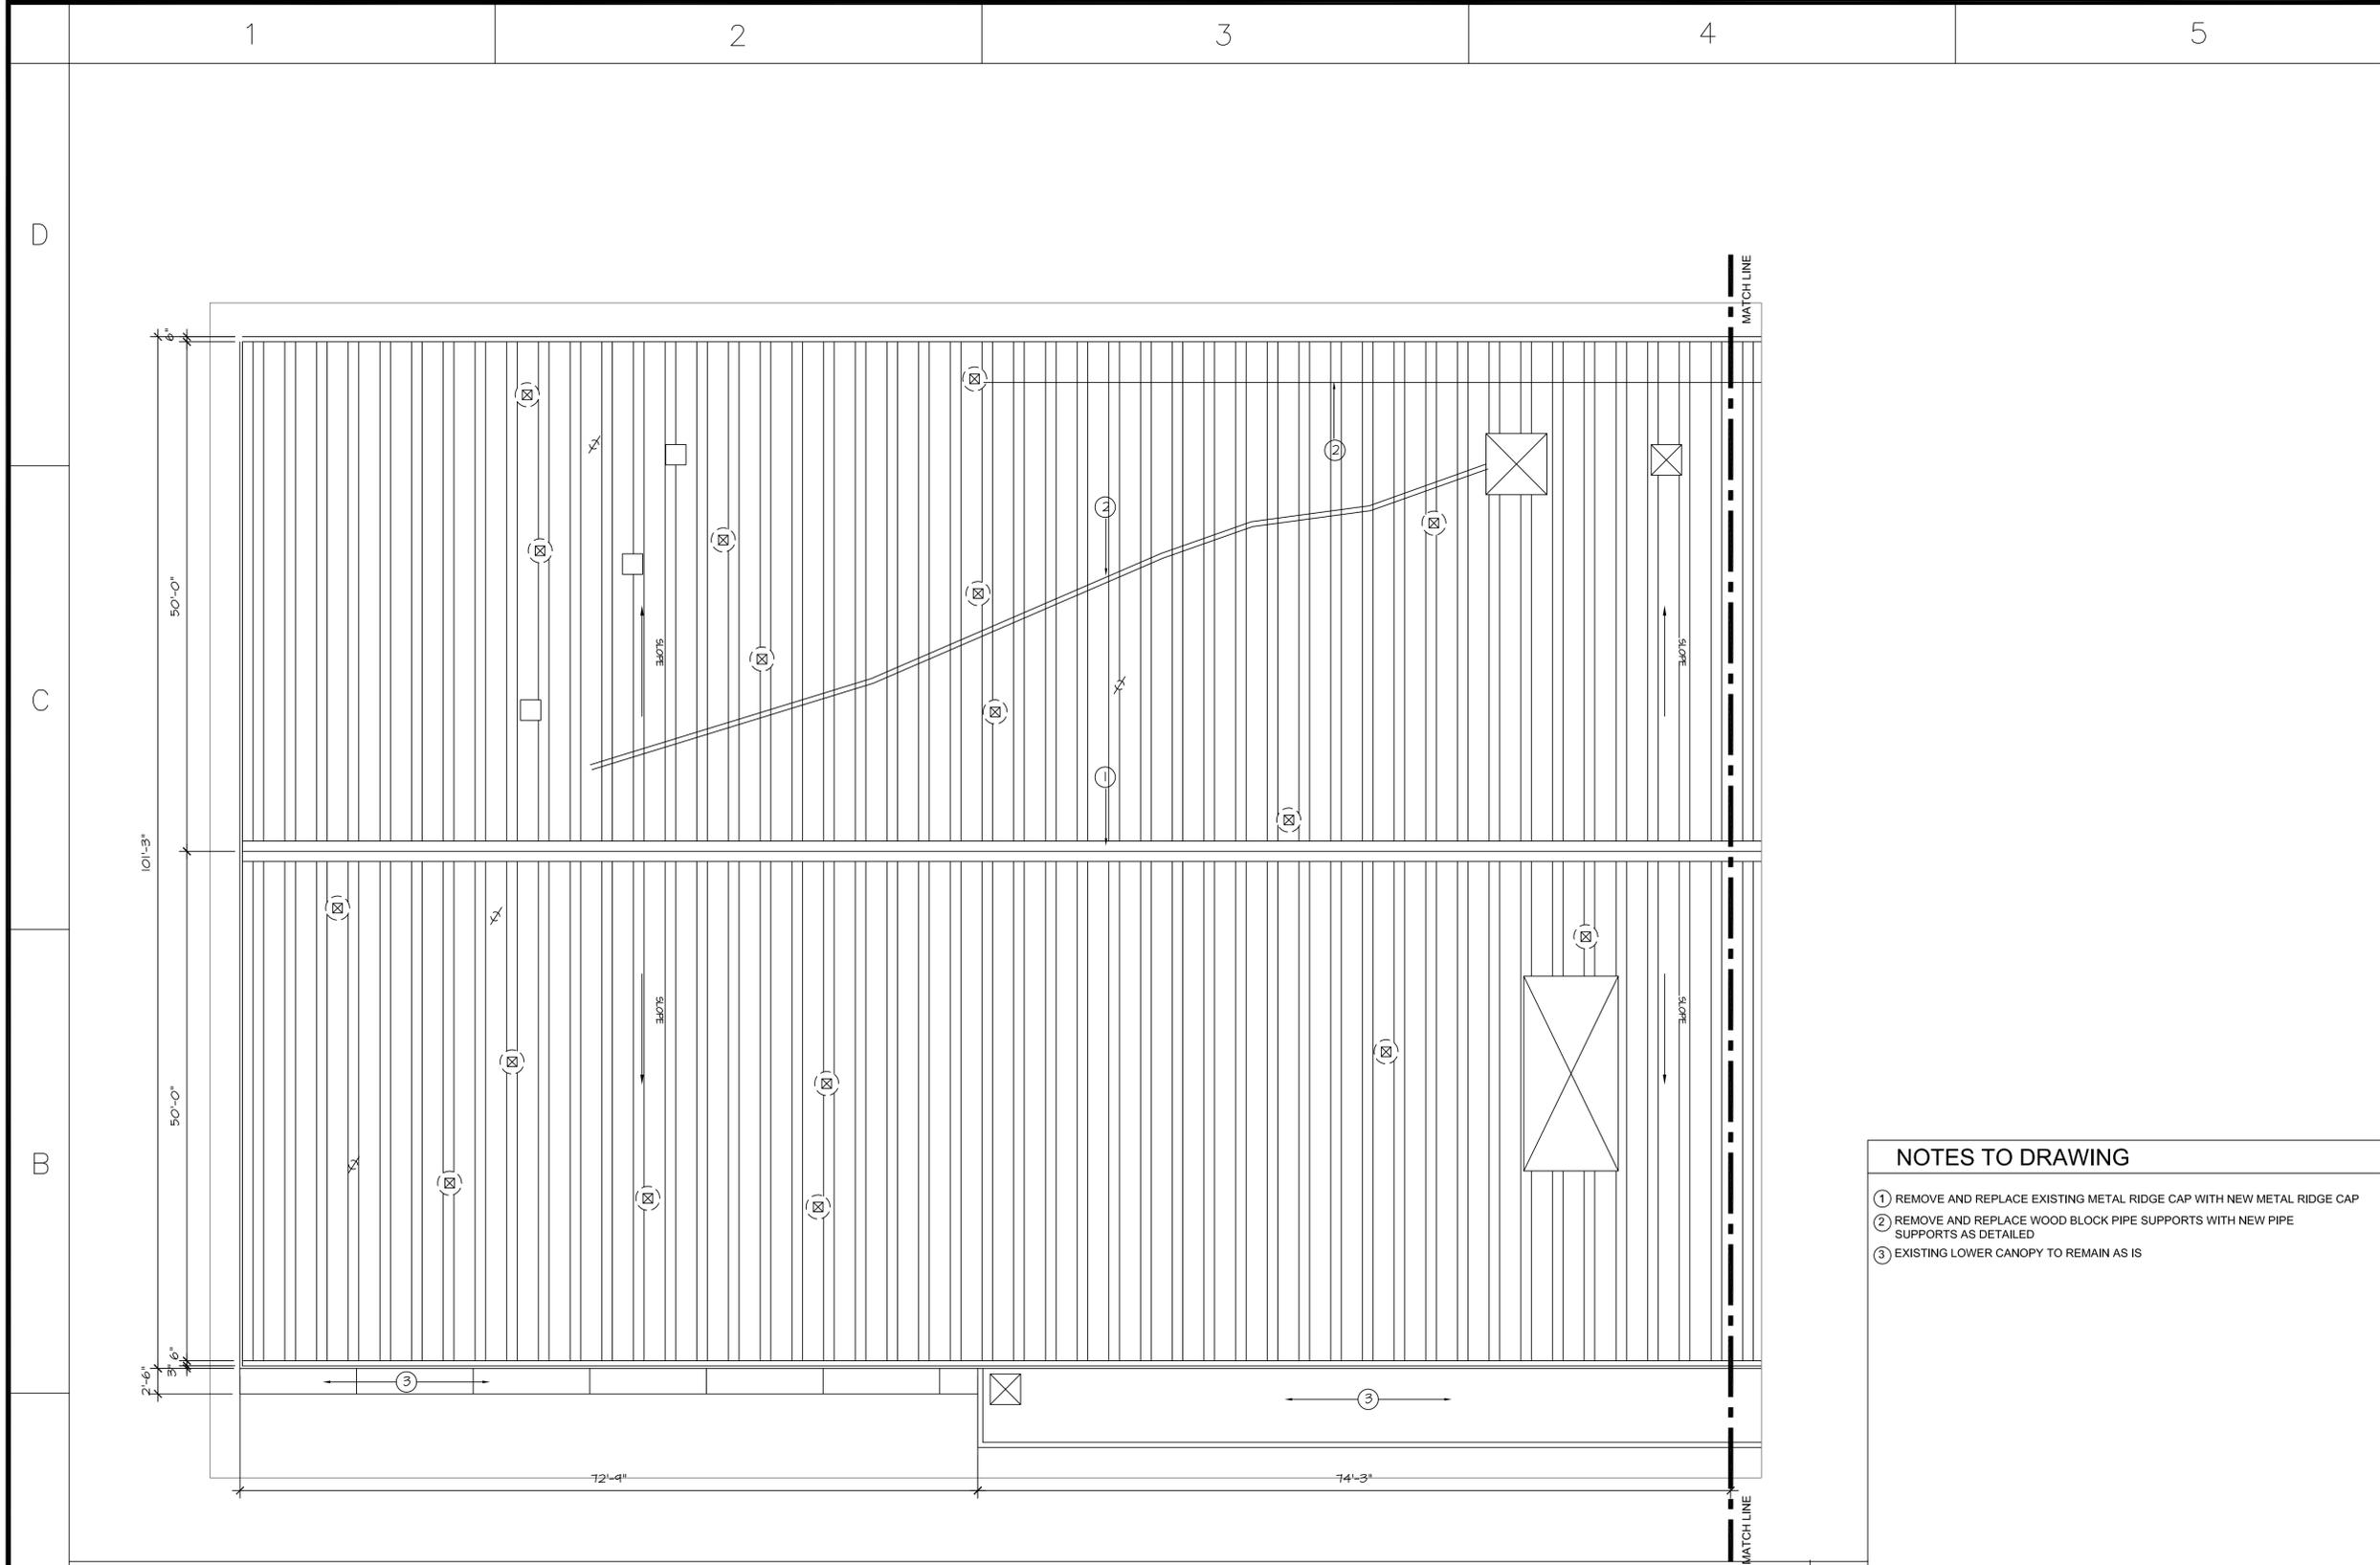

ENLARGED DEMOLITION ROOF PLAN

SCALE: 1/16" = 1'-0"

1

SOIL/PLUMBING VENT	FLANGE MOUNTED EQUIPMENT	HOT STACK	CURB MOUNTED VENT	A/C UNIT	CURB MOUNTED EQUIPMENT	MISCELLANEOUS EQUIPMENT ON PP	PRIMARY ROOF DRAIN	OVERFLOW ROOF DRAIN	PRIMARY AND OVERFLOW ROOF DRAIN	DOWNSPOUT/SPLASHBLOCK	DOWNSPOUT	EXISTING ROOF DRAIN	EXPANSION JOINT	METAL EDGE W/GUTTER	METAL EDGE	RISE WALL	RAISED METAL EDGE	RISE WALL W/EXPANSION JOINT
PITCH PAN	PROCESS VENT STACK	VENT STACK	FLANGE MOUNTED VENT	PLENUM A/C ON PITCH PANS	MISCELLANEOUS EQUIPMENT	ROOF HATCH	SCUPPER	OVERFLOW SCUPPER	EDGE SCUPPER	DOWNSPOUT/ COLLECTOR HEAD	THROUGH WALL SCUPPER	EXISTING OVERFLOW ROOF DRAIN	PARAPET	EXPANSION JOINT AT PARAPET	SLOPE DIRECTION	EXISTING PARAPET	METAL WALL PANELS	SKYLIGHT

ROOF LEGEND

PRE-FINISHED STANDING SEAM METAL ROOF AS SPECIFIED
ROOF SYSTEM AS SPECIFIED
NOT IN CONTRACT

NOTES TO DRAWING

- ① REMOVE AND REPLACE EXISTING METAL RIDGE CAP WITH NEW METAL RIDGE CAP
- ② REMOVE AND REPLACE WOOD BLOCK PIPE SUPPORTS WITH NEW PIPE SUPPORTS AS DETAILED
- ③ EXISTING LOWER CANOPY TO REMAIN AS IS

ISSUE LOG		
NO.	DATE	DESCRIPTION

CITY OF HOUSTON
GENERAL SERVICES
DEPARTMENT



900 BAGBY, HOUSTON, TX 77002

PROJECT NAME :
2903 JENSEN DRIVE
ROOF REPAIR/ COATING AND
PARKING LOT REPAIR
AND RESURFACING
VICTORY PREPARATORY ACADEMY
(PROJ#-P-000011)

APPROVALS :

PROJECT MANAGER _____	DATE _____
CHIEF ENGINEER _____	DATE _____
ASSISTANT DIRECTOR _____	DATE _____

CONSULTANT:



ARCHI*TECHNICS/3
5555 West Loop S, Suite 400
Bellaire, Texas 77401
713/868-0088 713/468-2613



ims
INTEGRATED MANAGEMENT SERVICES, P.A. INC.
ENGINEERS PLANNERS PROJECT MANAGERS
723 MAIN STREET, SUITE 250
HOUSTON, TEXAS 77002
OFFICE #713-739-7744
FAX#713-739-7746

PROJECT NO : P-000011
ACAD DWG. FILE :
DRAWN BY : JA
CHECKED BY : MRJ
COPY RIGHT :

SHEET TITLE :
ENLARGED DEMOLITION ROOF PLAN

SHEET NO. 4 OF 8 SHEETS
CITY DWG NO :

1

2

3

4


5

D

C

B

A

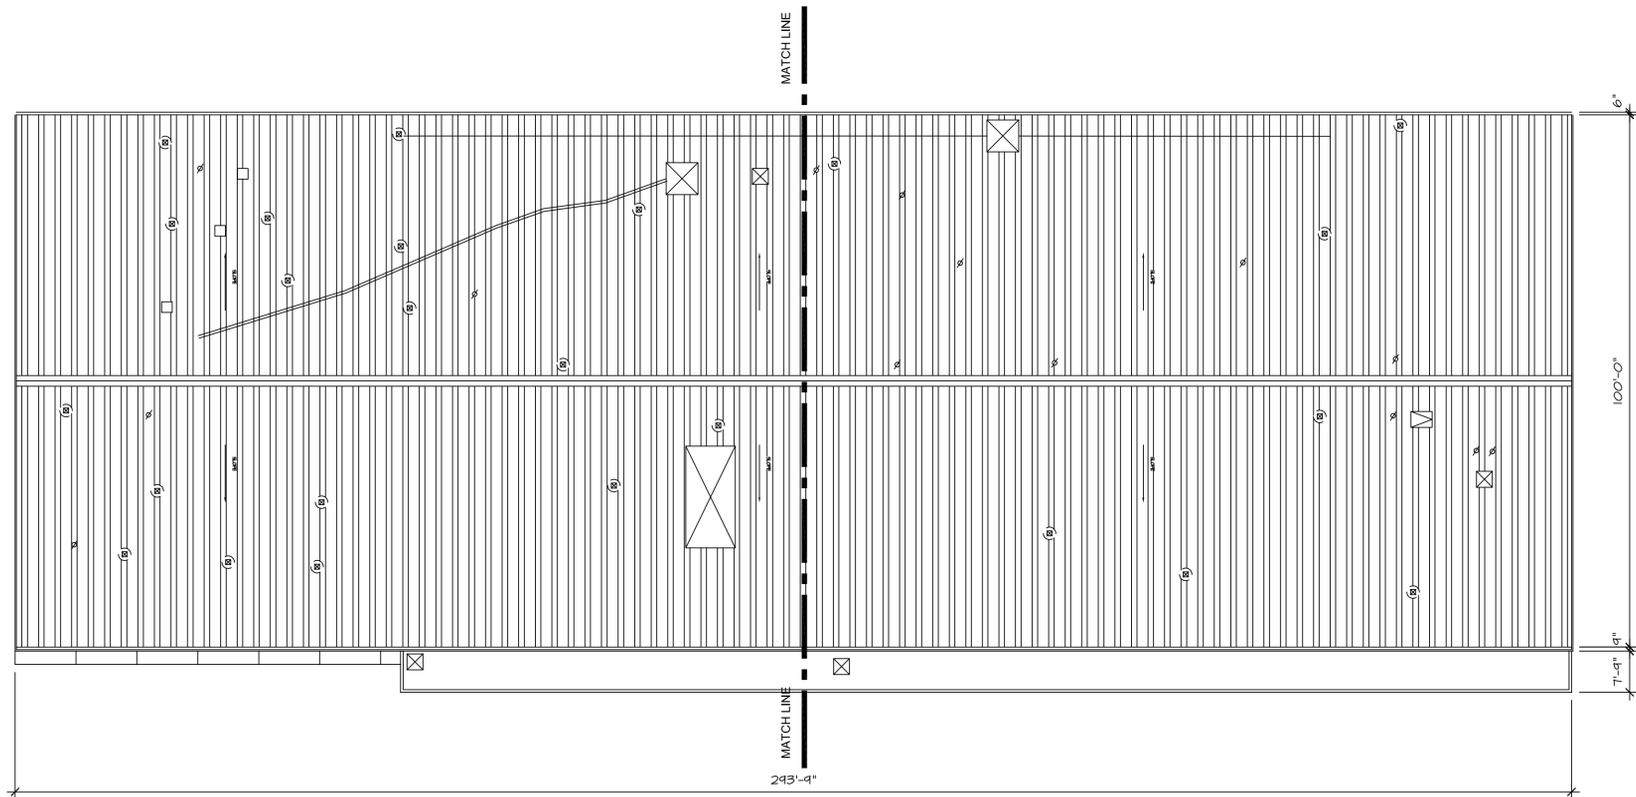

RENOVATED ROOF PLAN



SCALE: 1/16" = 1'-0"

1

ROOF LEGEND

SOIL/PLUMBING VENT	FLANGE MOUNTED EQUIPMENT	HOT STACK	CURB MOUNTED VENT	A/C UNIT	CURB MOUNTED EQUIPMENT	MISCELLANEOUS EQUIPMENT ON PP	PRIMARY ROOF DRAIN	OVERFLOW ROOF DRAIN	PRIMARY AND OVERFLOW ROOF DRAIN	DOWNSPOUT/SPLASHBLOCK	DOWNSPOUT	EXISTING ROOF DRAIN	EXPANSION JOINT	METAL EDGE W/GUTTER	METAL EDGE	RISE WALL	RAISED METAL EDGE	RISE WALL W/EXPANSION JOINT
PITCH PAN	PROCESS VENT STACK	VENT STACK	FLANGE MOUNTED VENT	PLENUM A/C ON PITCH PANS	MISCELLANEOUS EQUIPMENT	ROOF HATCH	SCUPPER	OVERFLOW SCUPPER	EDGE SCUPPER	DOWNSPOUT/ COLLECTOR HEAD	THROUGH WALL SCUPPER	EXISTING OVERFLOW ROOF DRAIN	PARAPET	EXPANSION JOINT AT PARAPET	SLOPE DIRECTION	EXISTING PARAPET	METAL WALL PANELS	SKYLIGHT

	PRE-FINISHED STANDING SEAM METAL ROOF AS SPECIFIED
	ROOF SYSTEM AS SPECIFIED
	NOT IN CONTRACT

ISSUE LOG		
NO.	DATE	DESCRIPTION

CITY OF HOUSTON
GENERAL SERVICES
DEPARTMENT



900 BAGBY, HOUSTON, TX 77002

PROJECT NAME :
2903 JENSEN DRIVE
ROOF REPAIR/ COATING AND
PARKING LOT REPAIR
AND RESURFACING
VICTORY PREPARATORY ACADEMY
 (PROJ#-P-000011)

APPROVALS :

PROJECT MANAGER _____	DATE _____
CHIEF ENGINEER _____	DATE _____
ASSISTANT DIRECTOR _____	DATE _____

CONSULTANT:

ARCHITECHNICS/3
 5555 West Loop S, Suite 400
 Bellaire, Texas 77401
 713/868-0088 713/468-2613

ims
 INTEGRATED MANAGEMENT SERVICES, P.A. INC.
 ENGINEERS PLANNERS PROJECT MANAGERS
 723 MAIN STREET, SUITE 250
 HOUSTON, TEXAS 77002
 OFFICE #713-739-7744
 FAX#713-739-7746

PROJECT NO : P-000011

ACAD DWG. FILE :

DRAWN BY : JA

CHECKED BY : MRJ


COPY RIGHT :

SHEET TITLE :
 ENLARGED RENOVATED ROOF PLAN

A-1.0

SHEET NO. 5 OF 8 SHEETS

CITY DWG NO :

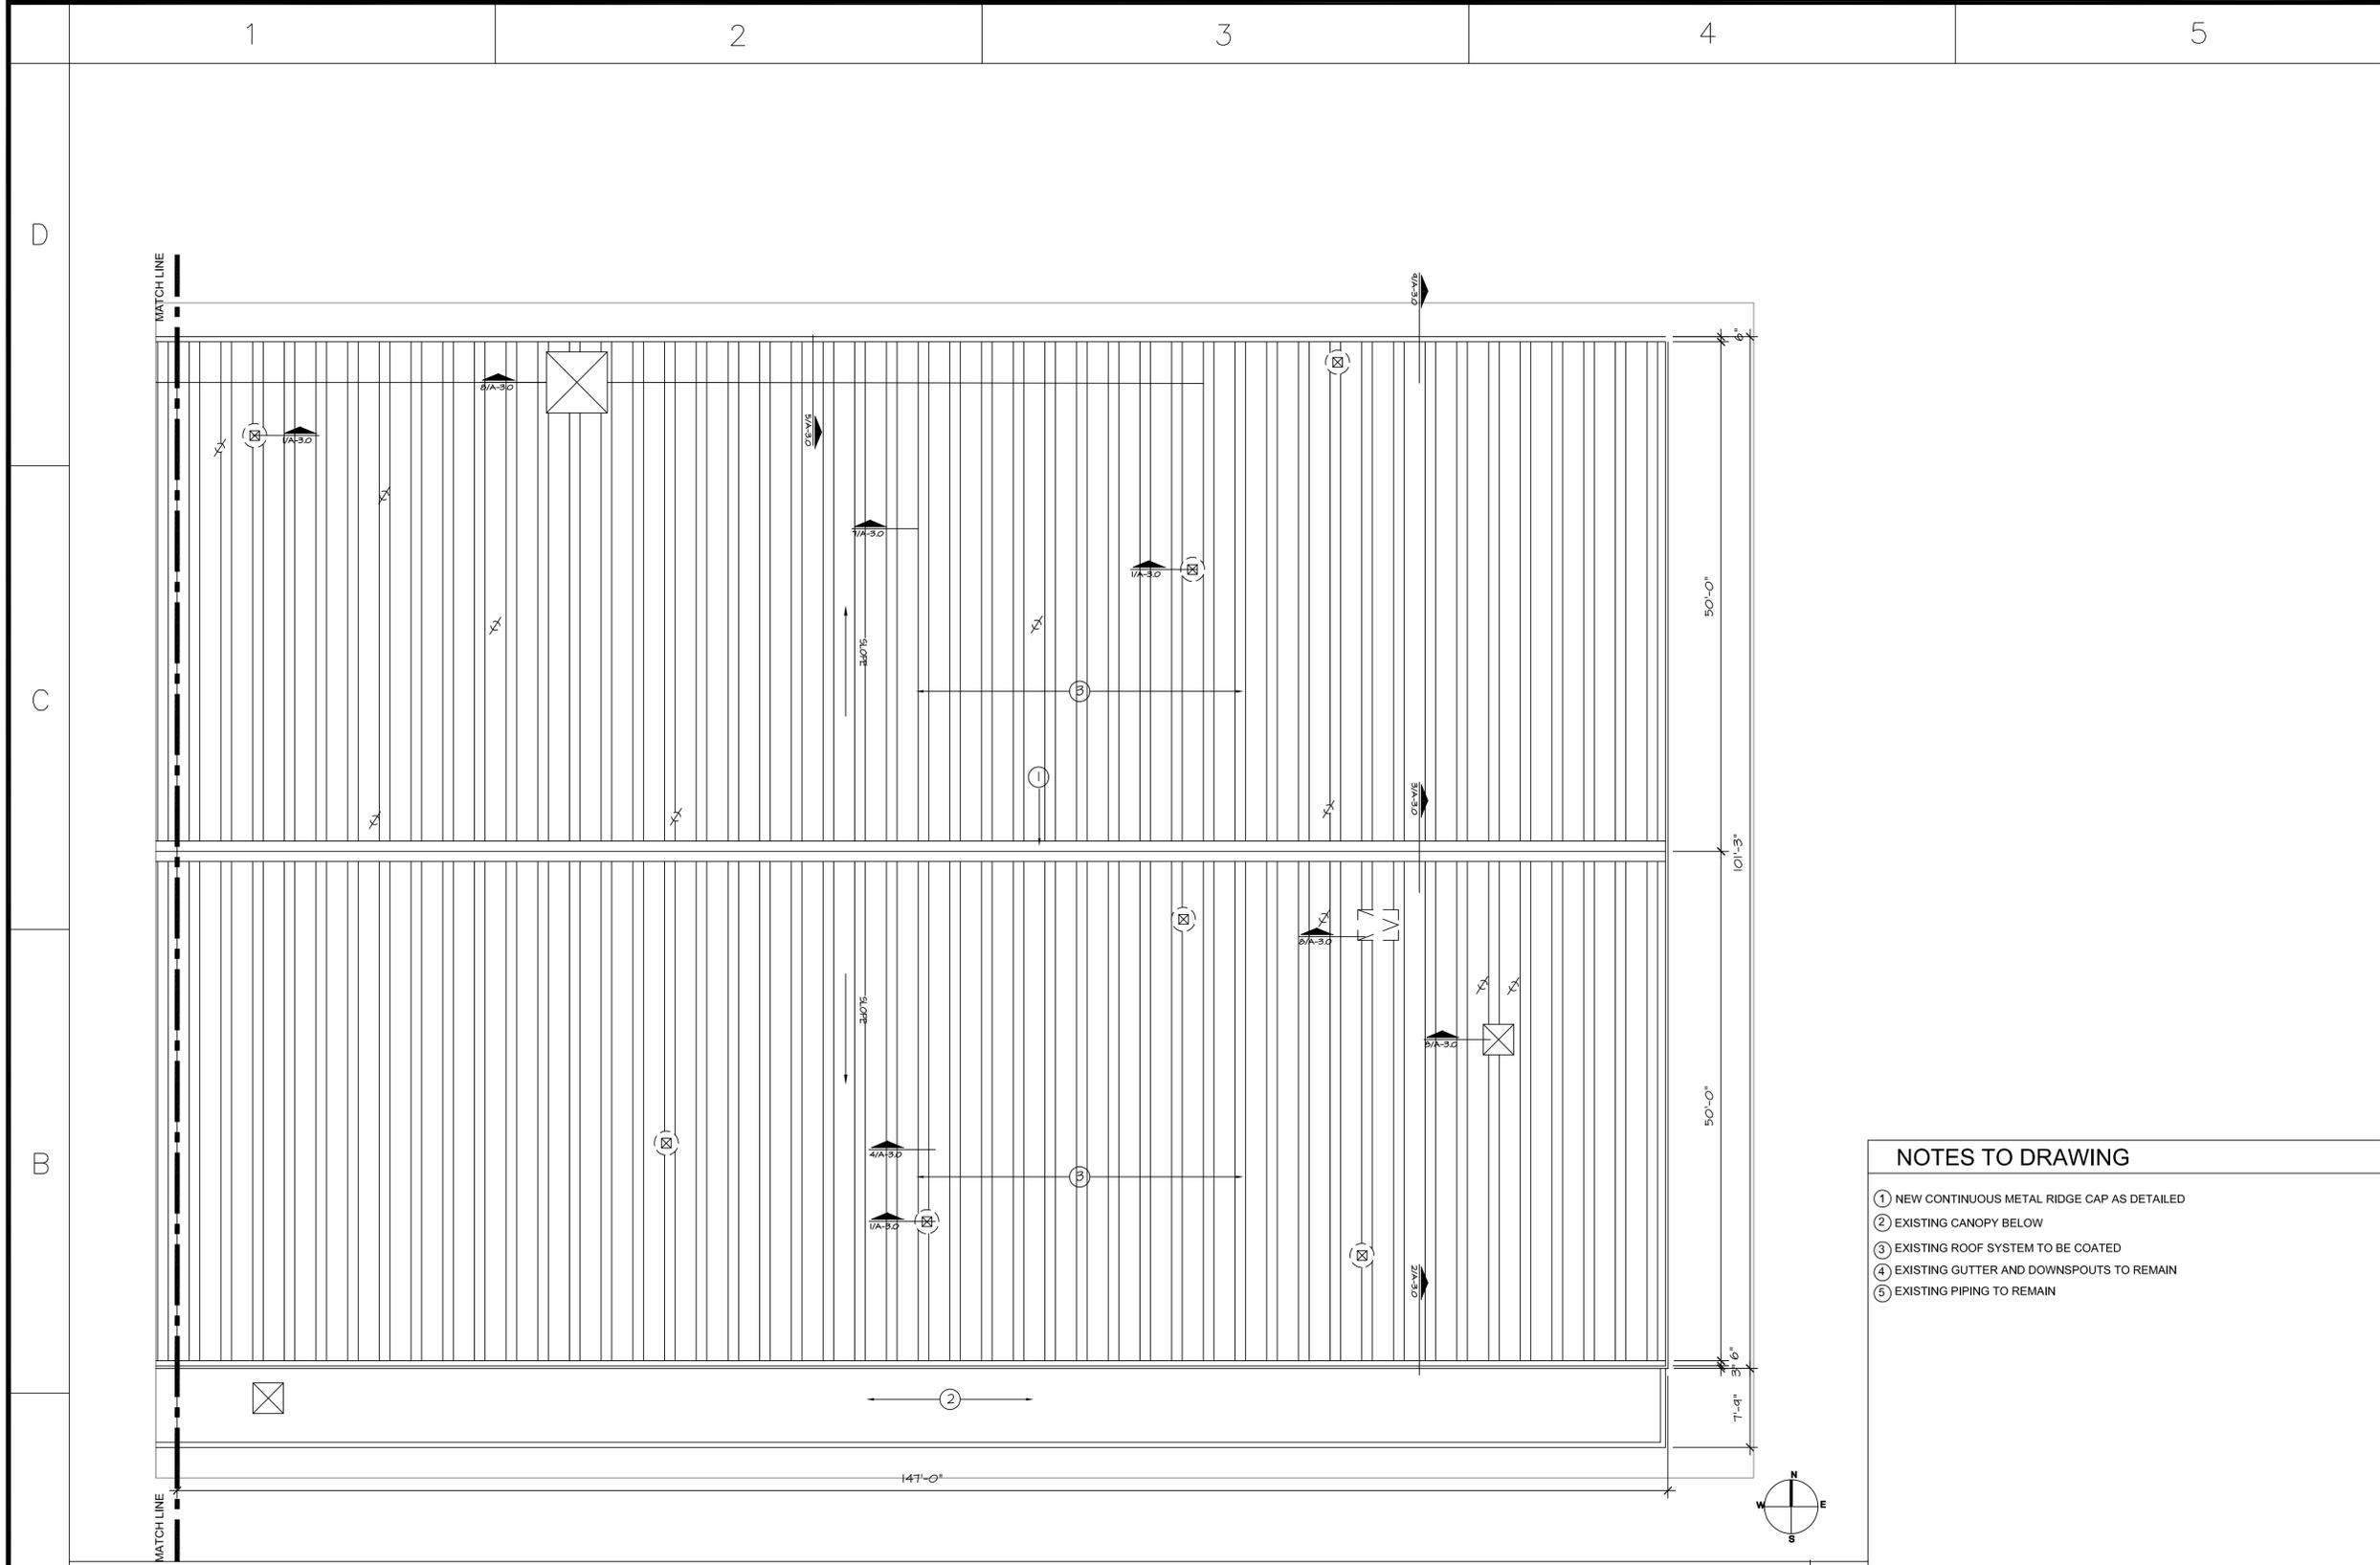

ENLARGED RENOVATED ROOF PLAN

SCALE: 1/16" = 1'-0"

1

SOIL/PLUMBING VENT	FLANGE MOUNTED EQUIPMENT	HOT STACK	CURB MOUNTED VENT	A/C UNIT	CURB MOUNTED EQUIPMENT	MISCELLANEOUS EQUIPMENT ON PP	PRIMARY ROOF DRAIN	OVERFLOW ROOF DRAIN	PRIMARY AND OVERFLOW ROOF DRAIN	DOWNSPOUT/SPLASHBLOCK	DOWNSPOUT	EXISTING ROOF DRAIN	EXPANSION JOINT	METAL EDGE W/GUTTER	METAL EDGE	RISE WALL	RAISED METAL EDGE	RISE WALL W/EXPANSION JOINT
PITCH PAN	PROCESS VENT STACK	VENT STACK	FLANGE MOUNTED VENT	PLENUM A/C ON PITCH PANS	MISCELLANEOUS EQUIPMENT	ROOF HATCH	SCUPPER	OVERFLOW SCUPPER	EDGE SCUPPER	DOWNSPOUT/ COLLECTOR HEAD	THROUGH WALL SCUPPER	EXISTING OVERFLOW ROOF DRAIN	PARAPET	EXPANSION JOINT AT PARAPET	SLOPE DIRECTION	EXISTING PARAPET	METAL WALL PANELS	SKYLIGHT

ROOF LEGEND

	PRE-FINISHED STANDING SEAM METAL ROOF AS SPECIFIED
	ROOF SYSTEM AS SPECIFIED
	NOT IN CONTRACT

NOTES TO DRAWING

- ① NEW CONTINUOUS METAL RIDGE CAP AS DETAILED
- ② EXISTING CANOPY BELOW
- ③ EXISTING ROOF SYSTEM TO BE COATED
- ④ EXISTING GUTTER AND DOWNSPOUTS TO REMAIN
- ⑤ EXISTING PIPING TO REMAIN

ISSUE LOG		
NO.	DATE	DESCRIPTION

**CITY OF HOUSTON
GENERAL SERVICES
DEPARTMENT**



900 BAGBY, HOUSTON, TX 77002

PROJECT NAME :
2903 JENSEN DRIVE
ROOF REPAIR/ COATING AND
PARKING LOT REPAIR
AND RESURFACING
VICTORY PREPARATORY ACADEMY
(PROJ#-P-000011)

APPROVALS :

PROJECT MANAGER _____	DATE _____
CHIEF ENGINEER _____	DATE _____
ASSISTANT DIRECTOR _____	DATE _____

CONSULTANT:

ARCHI*TECHNICS/3
5555 West Loop S, Suite 400
Bellaire, Texas 77401
713/868-0088 713/468-2613

ims
INTEGRATED MANAGEMENT SERVICES, P.A. INC.
ENGINEERS PLANNERS PROJECT MANAGERS
723 MAIN STREET, SUITE 250
HOUSTON, TEXAS 77002
OFFICE #713-739-7744
FAX#713-739-7746

PROJECT NO : P-000011

ACAD DWG. FILE :

DRAWN BY : JA


CHECKED BY : MRJ

COPY RIGHT :

SHEET TITLE :
ENLARGED RENOVATED ROOF PLAN

A-1.1
SHEET NO. 6 OF 8 SHEETS

CITY DWG NO :

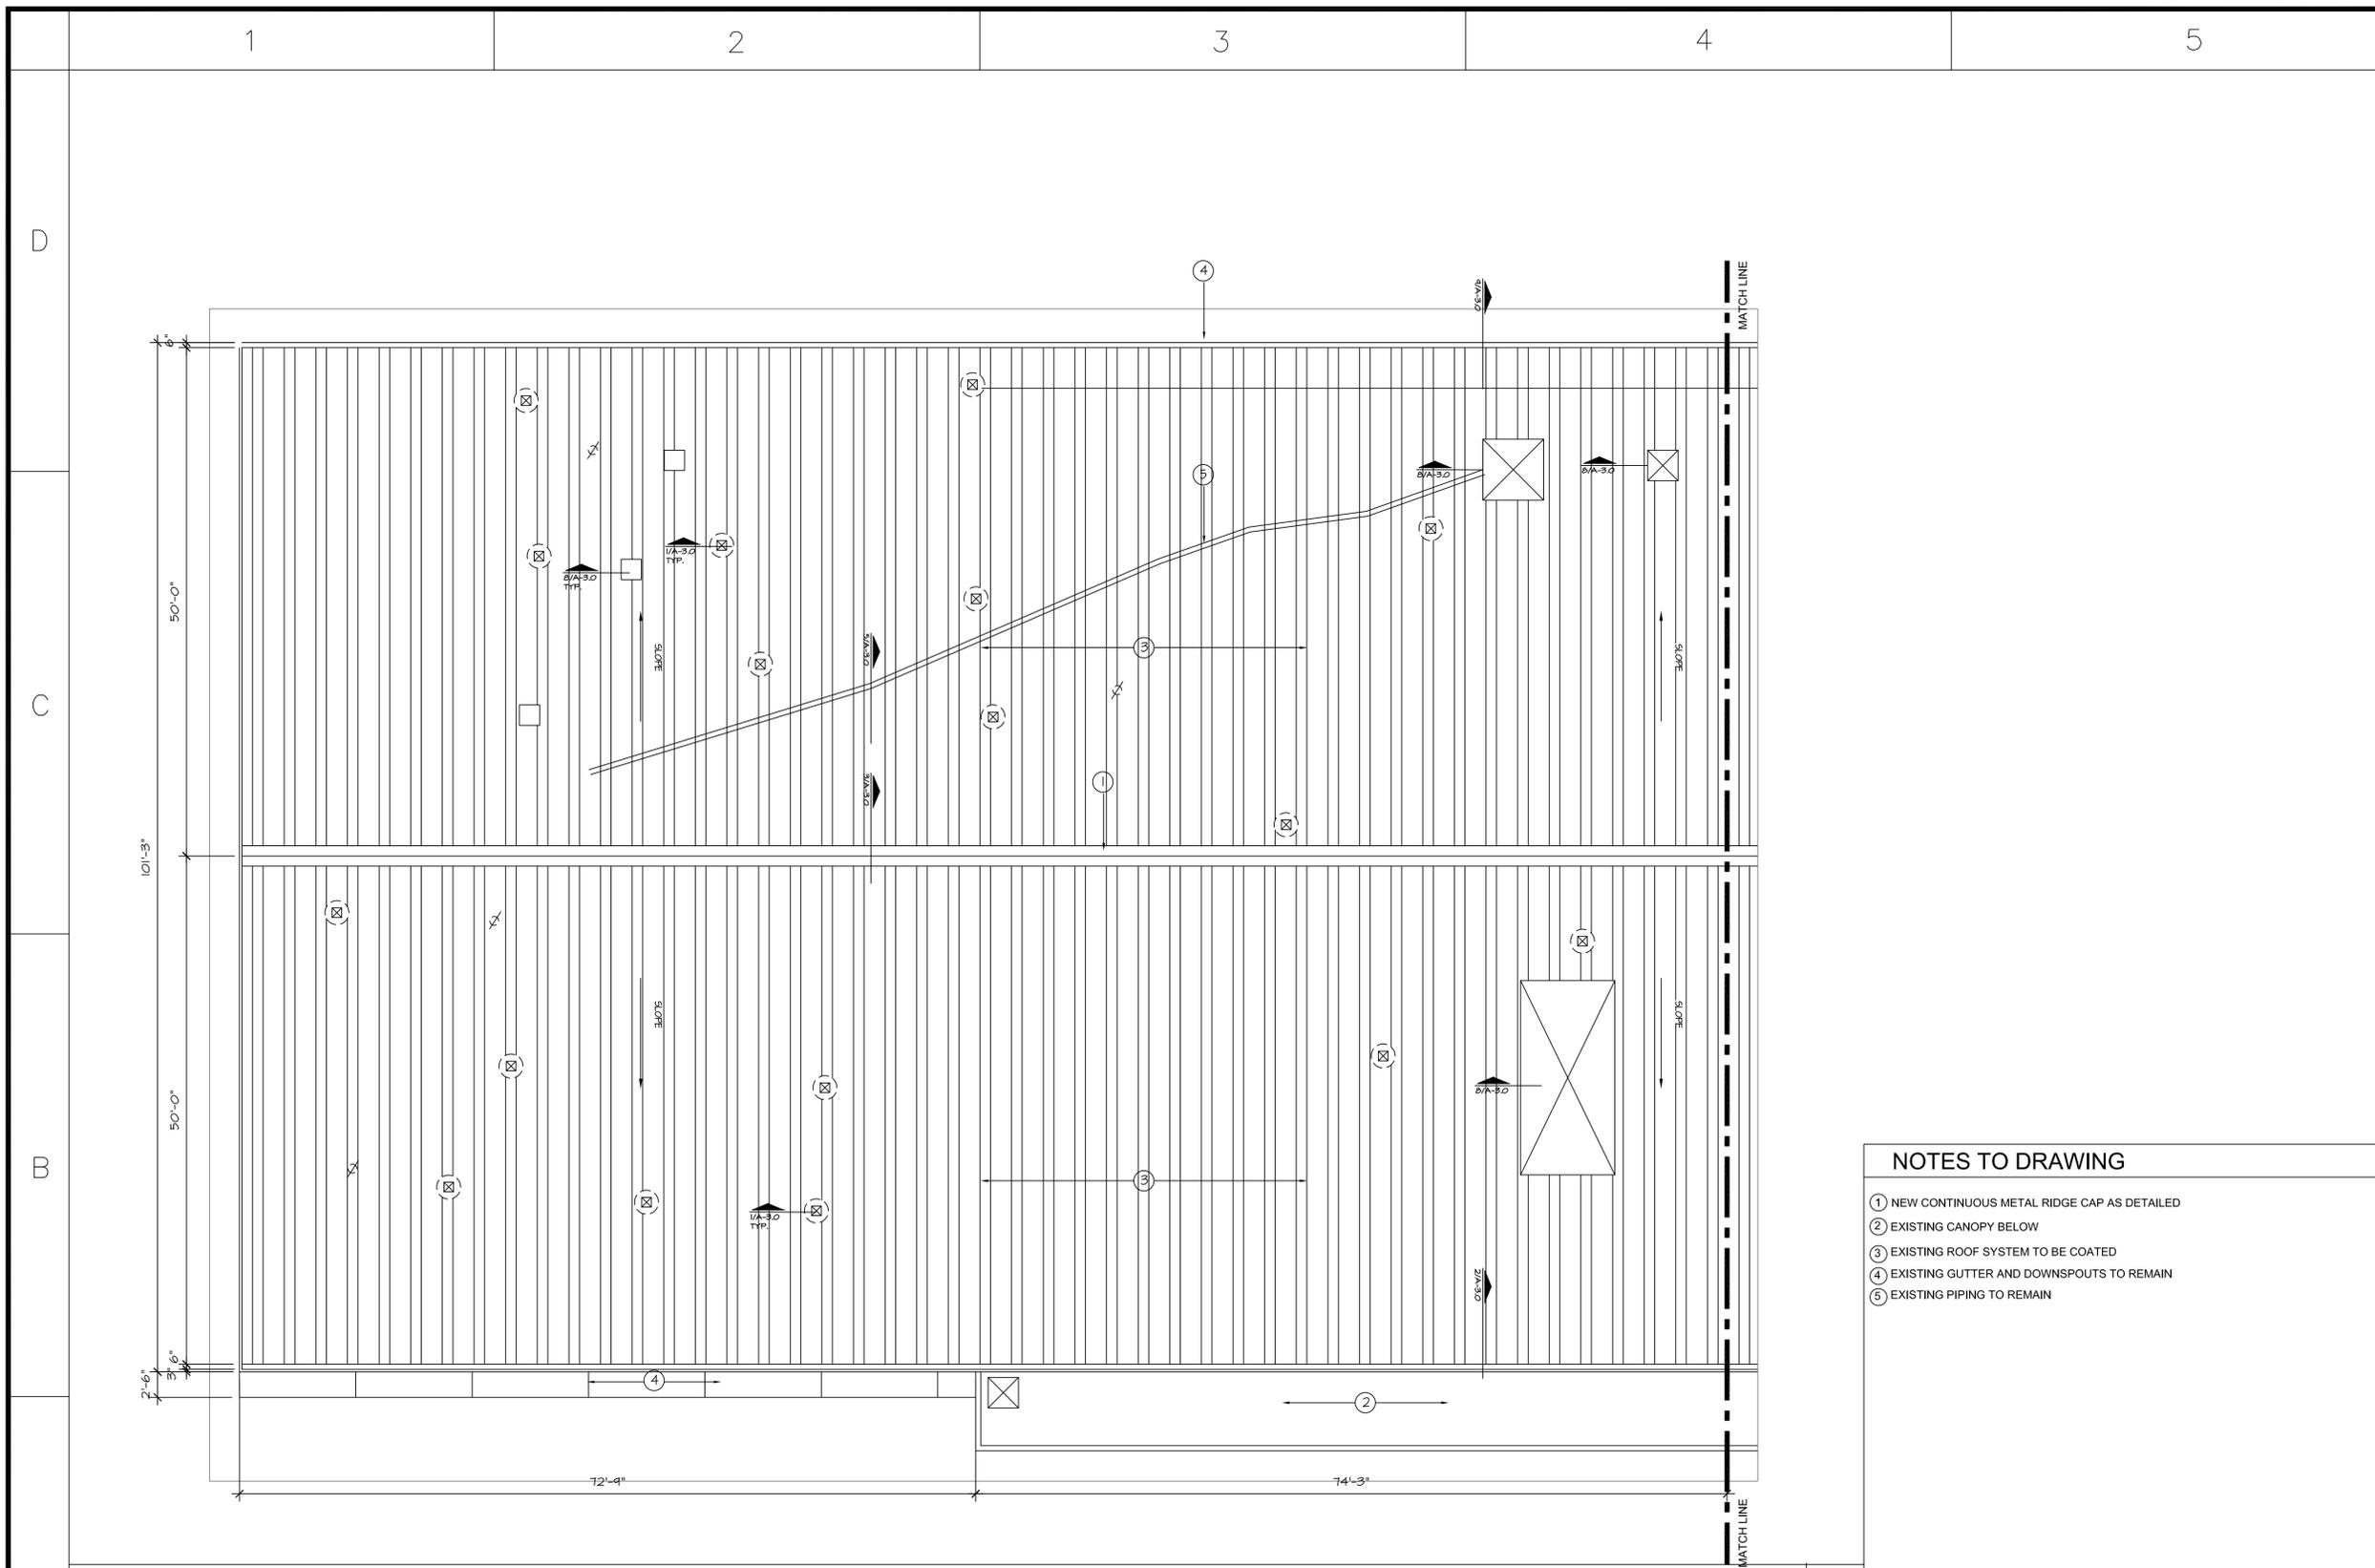

ENLARGED RENOVATED ROOF PLAN

SCALE: 1/16" = 1'-0"

1

ROOF LEGEND	
	PRE-FINISHED STANDING SEAM METAL ROOF AS SPECIFIED
	ROOF SYSTEM AS SPECIFIED
	NOT IN CONTRACT

NOTES TO DRAWING

- ① NEW CONTINUOUS METAL RIDGE CAP AS DETAILED
- ② EXISTING CANOPY BELOW
- ③ EXISTING ROOF SYSTEM TO BE COATED
- ④ EXISTING GUTTER AND DOWNSPOUTS TO REMAIN
- ⑤ EXISTING PIPING TO REMAIN

ISSUE LOG		
NO.	DATE	DESCRIPTION

CITY OF HOUSTON
GENERAL SERVICES
DEPARTMENT



900 BAGBY, HOUSTON, TX 77002

PROJECT NAME :
2903 JENSEN DRIVE
ROOF REPAIR/ COATING AND
PARKING LOT REPAIR
AND RESURFACING
VICTORY PREPARATORY ACADEMY
(PROJ#-P-000011)

APPROVALS :

PROJECT MANAGER _____	DATE _____
CHIEF ENGINEER _____	DATE _____
ASSISTANT DIRECTOR _____	DATE _____

CONSULTANT:

ARCHI*TECHNICS/3
5555 West Loop S, Suite 400
Bellaire, Texas 77401
713/868-0088 713/468-2613


ims
INTEGRATED MANAGEMENT SERVICES, P.A. INC.
ENGINEERS PLANNERS PROJECT MANAGERS
723 MAIN STREET, SUITE 250
HOUSTON, TEXAS 77002
OFFICE #713-739-7744
FAX#713-739-7746

PROJECT NO : P-000011
ACAD DWG. FILE :
DRAWN BY : JA
CHECKED BY : MRJ
COPY RIGHT :

SHEET TITLE :
ENLARGED RENOVATED ROOF PLAN

A-1.2
SHEET NO. 7 OF 8 SHEETS

CITY DWG NO :
NNNNNN

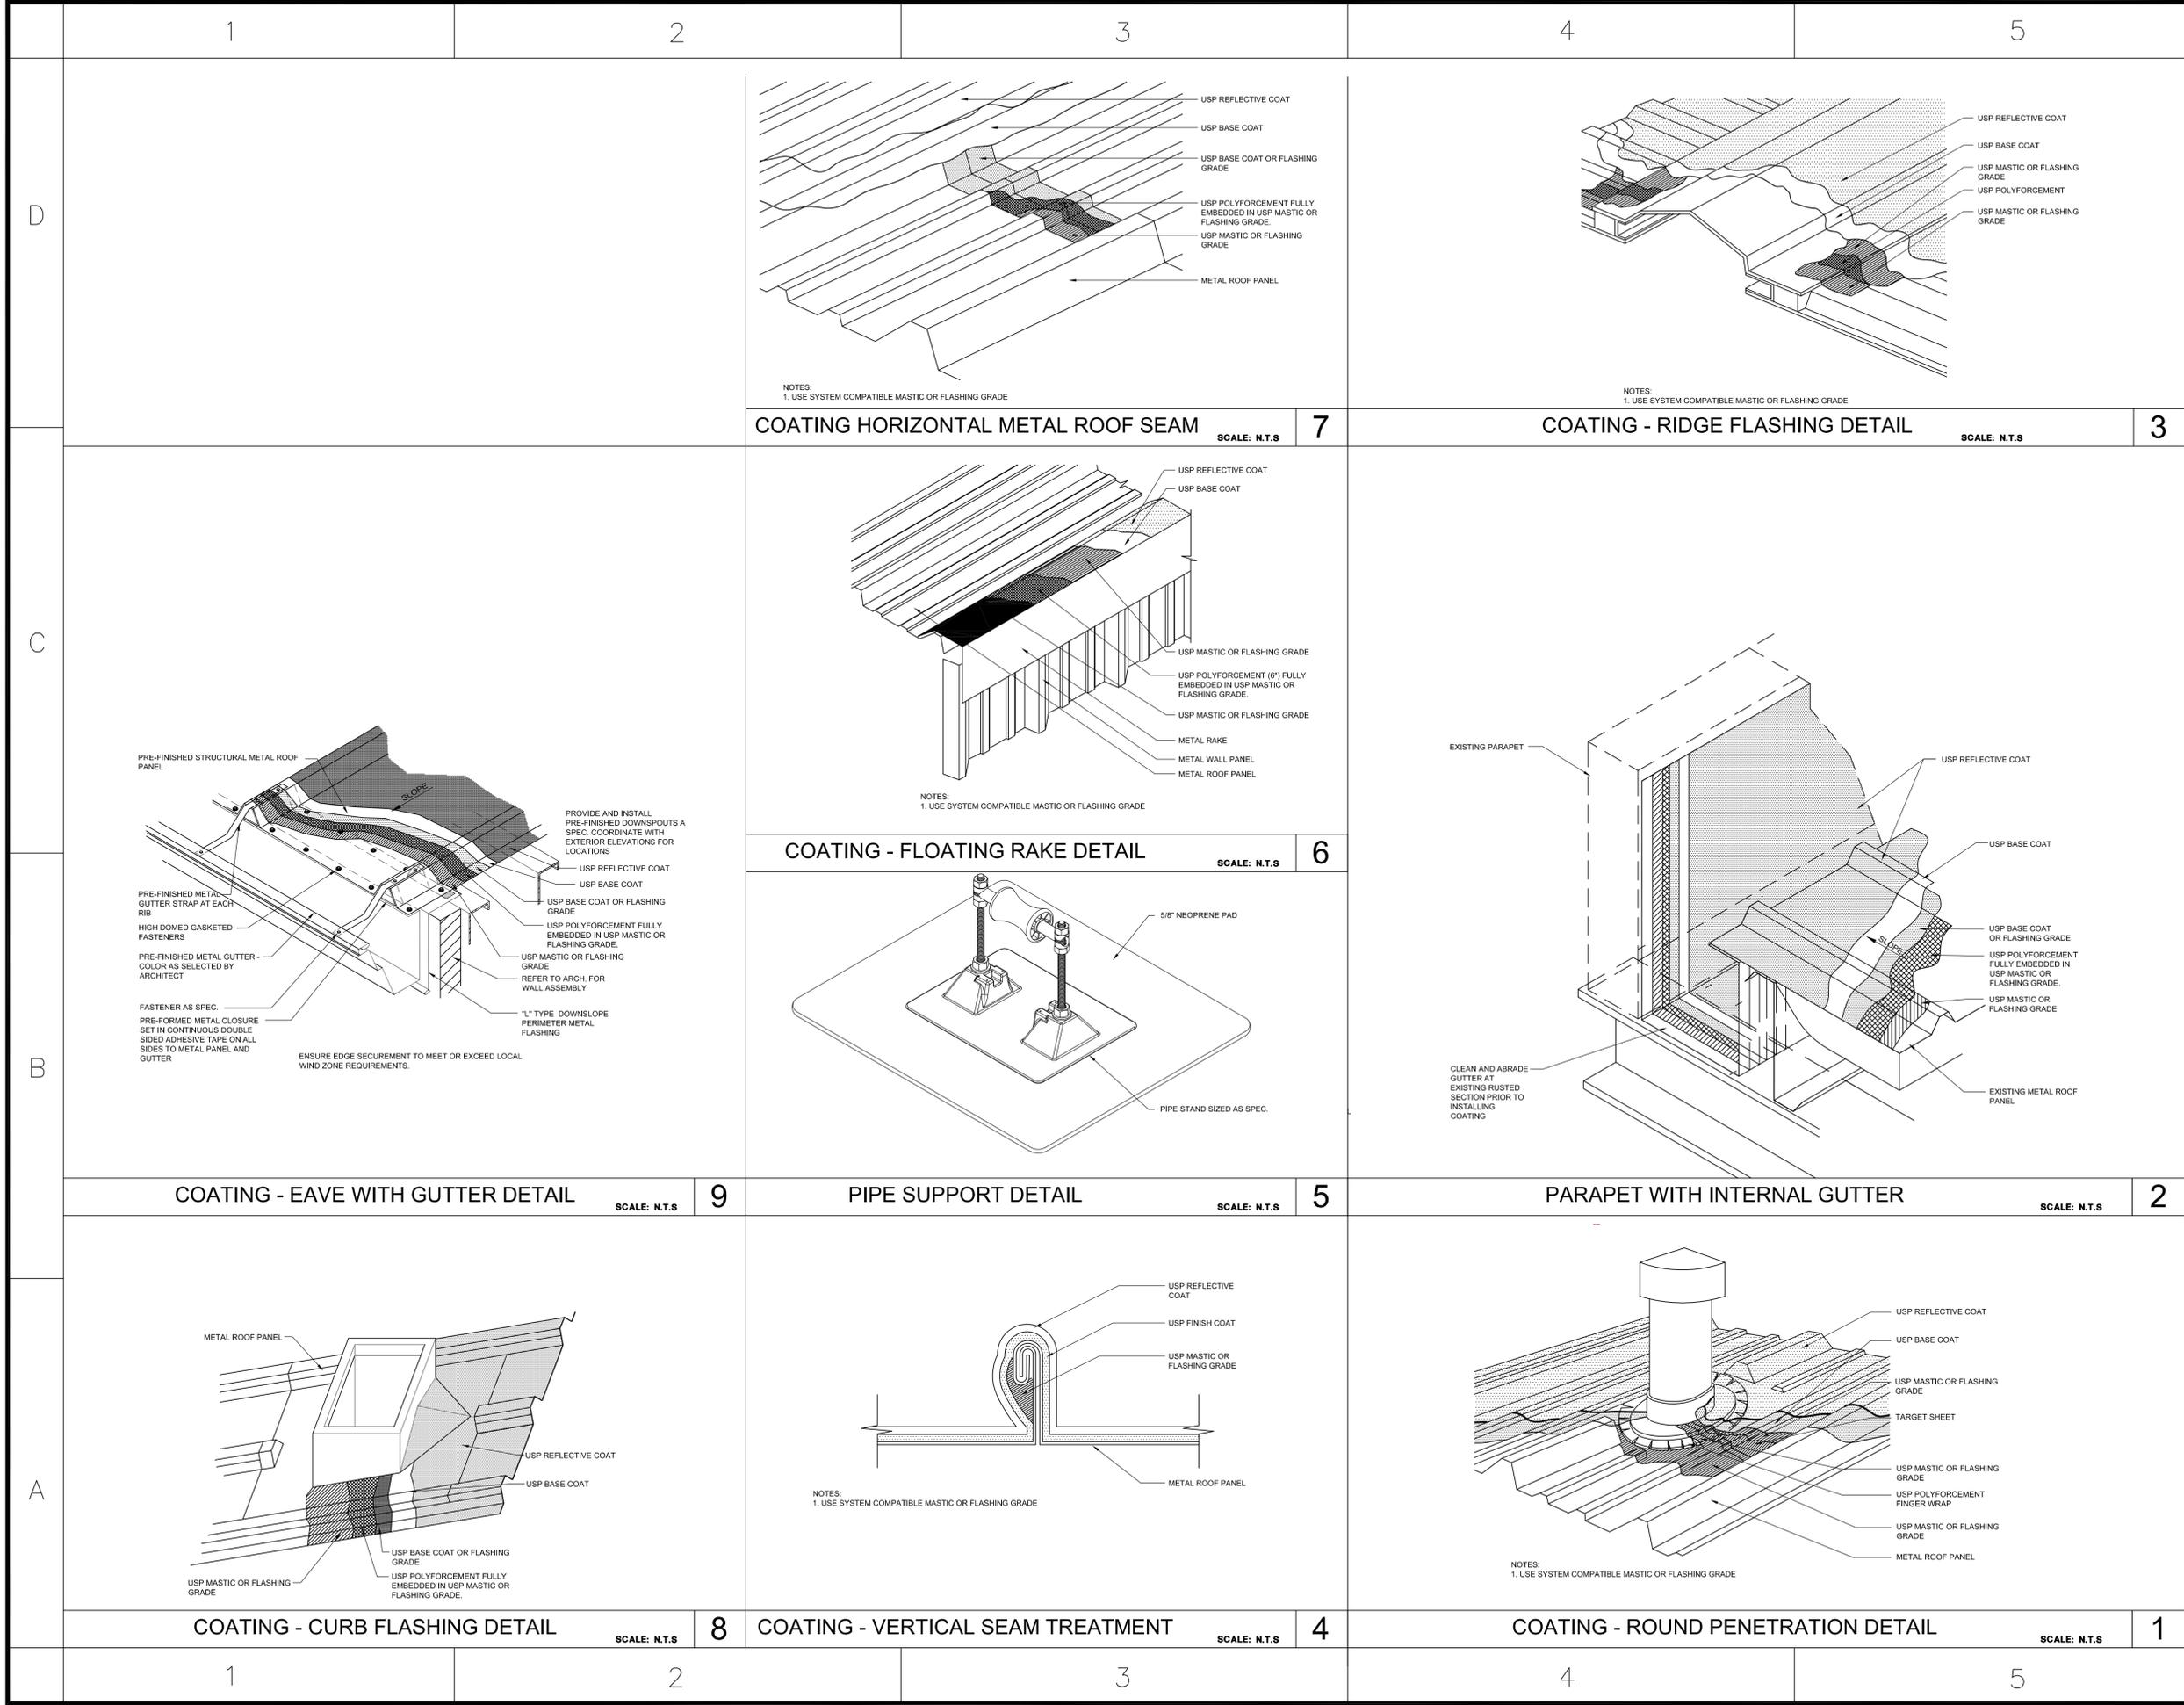

ISSUE LOG		
NO.	DATE	DESCRIPTION

CITY OF HOUSTON
GENERAL SERVICES DEPARTMENT



900 BAGBY, HOUSTON, TX 77002

PROJECT NAME :
2903 JENSEN DRIVE
ROOF REPAIR/ COATING AND
PARKING LOT REPAIR
AND RESURFACING
VICTORY PREPARATORY ACADEMY
(PROJ#-P-000011)

APPROVALS :

PROJECT MANAGER	DATE
CHIEF ENGINEER	DATE
ASSISTANT DIRECTOR	DATE

CONSULTANT:



ARCHI*TECHNICS/3
5555 West Loop S, Suite 400
Bellaire, Texas 77401
713/868-0088 713/468-2613

ims
INTEGRATED MANAGEMENT SERVICES, P.A. INC.
ENGINEERS PLANNERS PROJECT MANAGERS
723 MAIN STREET, SUITE 250
HOUSTON, TEXAS 77002
OFFICE #713-739-7744
FAX#713-739-7746

PROJECT NO : P-000011
ACAD DWG. FILE :
DRAWN BY : JA
CHECKED BY : MRJ
COPY RIGHT :
SHEET TITLE :
ROOF DETAILS

A-3.0

SHEET NO. 8 OF 8 SHEETS

CITY DWG NO :